

SPACE SUMMARY:			
OFFICES	5		
WORKSTATIONS	351		
TOTAL:	356		
CONF. ROOMS LARGE	3		
CONF. ROOMS MEDIUM	18		
CONF. ROOMS SMALL	20		
TRAINING ROOM (70p)	1		
PHONE ROOMS	6		
TOTAL:	48		
CONFERENCE SEATS:	221	CONFERENCE RATIO:	0.86
OPEN COLLAB SEATS:	248	OPEN COLLAB RATIO:	0.70
TOTAL MTG SEATS:	469	MEETING RATIO:	1.56

PLUMBING FIXTURE SCHEDULE:

	REQ'D	PROV.	
WOMENS *	9	14	60% above Code
MENS *	9	18	100% above Code
TOTAL:	18	32	

* NOTE:

(2) additional unisex, single occupancy bathrooms are provided (not included in count above)



PERKINS— **EASTMAN** Stamford, CT 06901 T. +1 203 251 7474 F. +1 203 251 7444

PROJECT: 275 MAIN STREET


DRAWING TITLE: WHITE PLAINS, NEW YORK

DATE: MAY 25TH, 2022 (UPDATED JUNE 16th, 2022) 2ND FLOOR TESTFIT

PROJECT NO.

SCALE: 1/16"=1'-0"

TF-02 DWG. NO.:

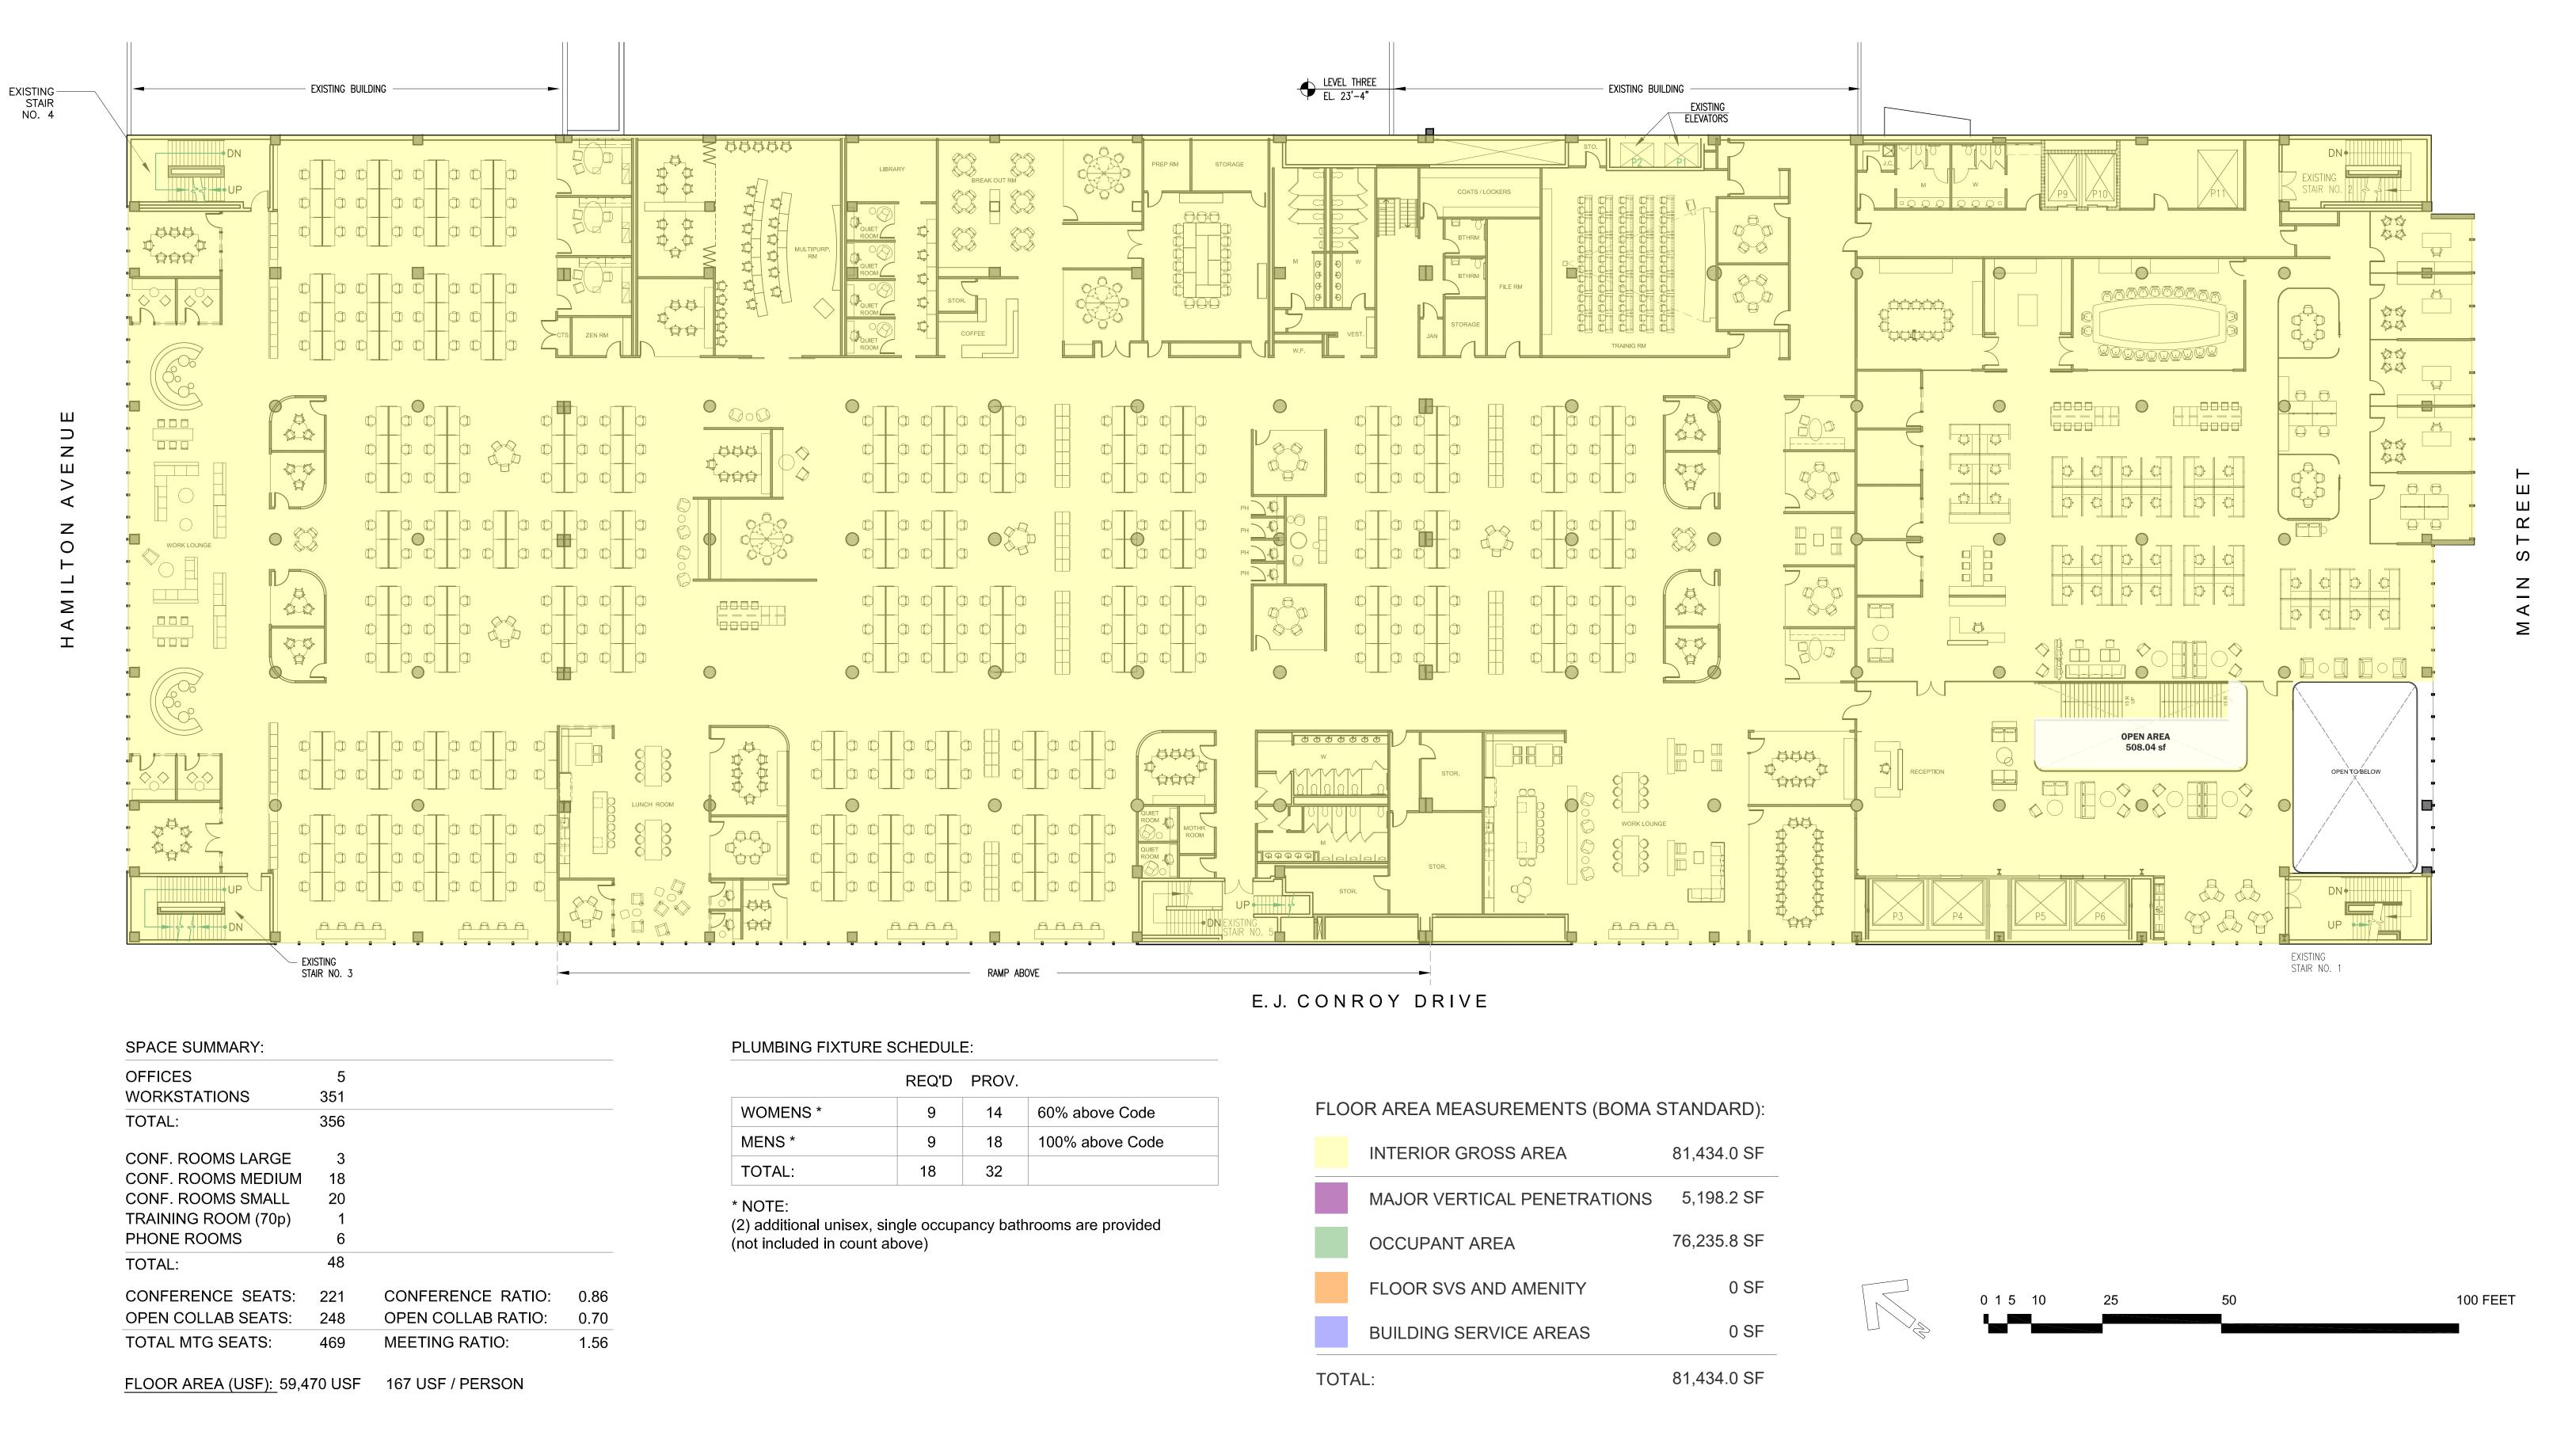

PERKINS—
EASTMAN
677 Washington Boulevard
Stamford, CT 06901
T. +1 203 251 7474
F. +1 203 251 7444

PROJECT: 275 MAIN STREET

DRAWING TITLE: WHITE PLAINS, NEW YORK

DATE: MAY 25TH, 2022 (UPDATED JUNE 16th, 2022)

2ND FLOOR TESTFIT

PROJECT NO.

SCALE: 1/16"=1'-0"

DWG. NO.: **TF-02**



PERKINS—
EASTMAN
677 Washington Boulevard
Stamford, CT 06901
T. +1 203 251 7474
F. +1 203 251 7444

PROJECT: 275 MAIN STREET

DRAWING TITLE: WHITE PLAINS, NEW YORK

DATE: MAY 25TH, 2022 (UPDATED JUNE 16th, 2022)

2ND FLOOR TESTFIT

PROJECT NO.

SCALE: 1/16"=1'-0"

DWG. NO.: **TF-02**